


C.W.M.S. No. 271

KANGAROO ISLAND COUNCIL

TOWNSHIP OF PENNESHAW

COMMUNITY WASTEWATER MANAGEMENT SCHEME

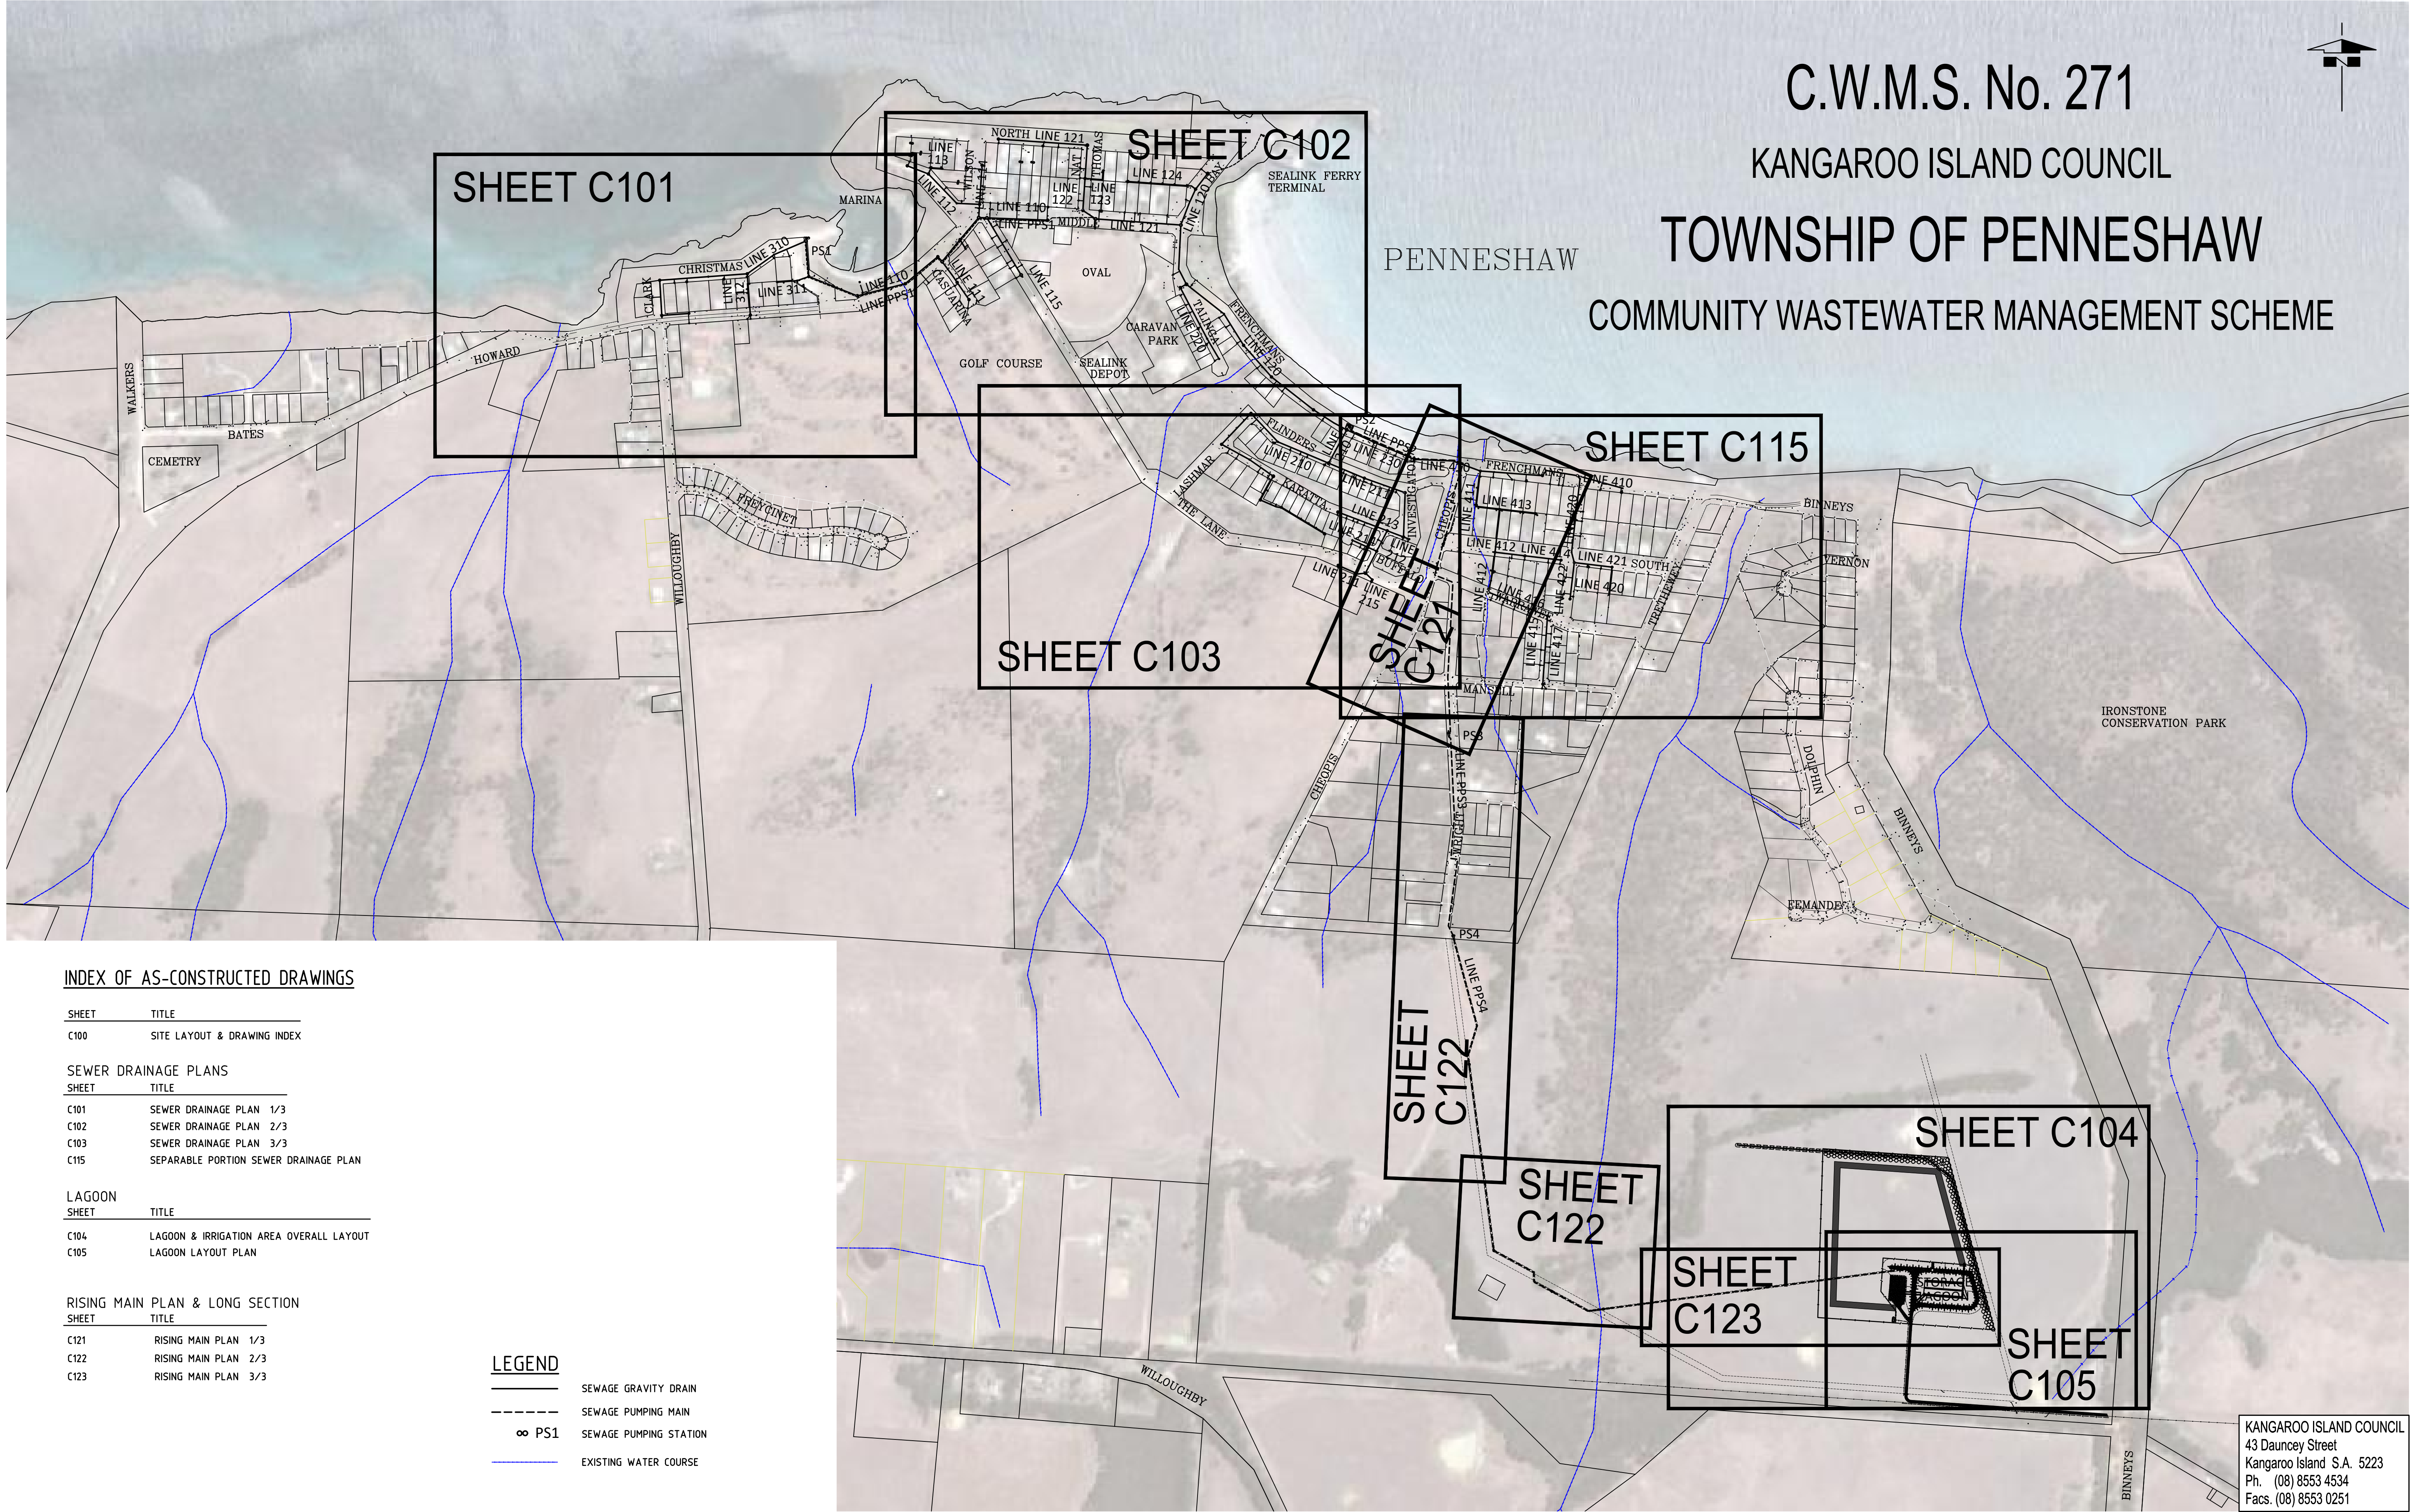

INDEX OF AS-CONSTRUCTED DRAWINGS

SHEET	TITLE
C100	SITE LAYOUT & DRAWING INDEX
SEWER DRAINAGE PLANS	
SHEET	TITLE
C101	SEWER DRAINAGE PLAN 1/3
C102	SEWER DRAINAGE PLAN 2/3
C103	SEWER DRAINAGE PLAN 3/3
C115	SEPARABLE PORTION SEWER DRAINAGE PLAN
LAGOON	
SHEET	TITLE
C104	LAGOON & IRRIGATION AREA OVERALL LAYOUT
C105	LAGOON LAYOUT PLAN
RISING MAIN PLAN & LONG SECTION	
SHEET	TITLE
C121	RISING MAIN PLAN 1/3
C122	RISING MAIN PLAN 2/3
C123	RISING MAIN PLAN 3/3

LEGEND	
	SEWAGE GRAVITY DRAIN
	SEWAGE PUMPING MAIN
	PS1 SEWAGE PUMPING STATION
	EXISTING WATER COURSE



OVERALL CONTOURS:
CONTOUR INTERVAL APPROX. 10 metres
(OVERALL CONTOURS INDICATE GENERAL TOPOGRAPHY ONLY AND ARE NOT ACCURATE)

Information used in this application was derived from digital databases sourced by Kangaroo Island Council.
Therefore, Kangaroo Island Council cannot accept any responsibility for any errors, omissions, or positional accuracy displayed on these maps.

AS CONSTRUCTED

REV.	DATE	DESCRIPTION	DRAFT	ENG.	CHKD
A	04.06.14	COUNCIL APPROVAL	AW	MM	
B	03.10.14	ISSUE FOR DAC	JPF	MM	
C	01.04.15	ISSUE FOR TENDER	JJW	TB	
D	27.04.15	ISSUE FOR TENDER	JJF	TB	
0	23.11.2015	CONSTRUCTION ISSUE	JPF	TB	
I	04.04.18	AS CONSTRUCTED	GPB	MD	

W&G
WALLBRIDGE & GILBERT
Consulting Engineers
60 Wyatt Street Adelaide South Australia 5000
Telephone (08) 8223 7433 Facsimile (08) 8232 0967
Email adelaide@wgeng.com
W&G Engineers Pty Ltd ACN 052 528 926
trading as Wallbridge & Gilbert

PENNESHAW CWMS No. 271
KANGAROO ISLAND COUNCIL
KANGAROO ISLAND, SOUTH AUSTRALIA
SITE LAYOUT & DRAWING INDEX

A1 Design MM	DRAWING NUMBER Job Number Sheet No. Rev. C070466 C100 1
---------------------------	---



LEGEND:

GRAVITY SEWER MAIN

RISING MAIN

HYDRANT VALVE, STOP VALVE, AIR VALVE

SEWER INSPECTION OPENING (IO)

MAINTENANCE SHAFT (MS, MSJ OR TMS)

MAINTENANCE HOLE (MH)

PROPERTY CONNECTION

PROPERTY CONNECTION SURFACE LEVEL

PROPERTY CONNECTION INVERT LEVEL

DEPTH OF CONNECTION

MONO INVISIQ PUMP CHAMBER

EXISTING WATERMAIN

EXISTING TELSTRA CABLE

EXISTING STORMWATER PIPE

When sheet printed full size, the scale bar is 100mm.

0

50

100mm

Information used in this application was derived from digital databases sourced by Kangaroo Island Council. Therefore, Kangaroo Island Council cannot accept any responsibility for any errors, omissions, or positional accuracy displayed on these maps.

AS CONSTRUCTED

20

10

0

20

40

metres

SCALE 1:1000

REV.	DATE	DESCRIPTION	DRAFT	ENG.	CHKD
C	01.04.15	ISSUE FOR TENDER	JJW	TB	
D	27.04.15	ISSUE FOR TENDER	JJF	TB	
E	28.09.2015	TENDER ISSUE, ALLOTMENT 135 BOUNDARY CORRECTED	JPF	TB	
Ø	23.11.2015	CONSTRUCTION ISSUE	JPF	TB	
1	07.03.16	LINE 310 & 316 AMENDED	CJH	TB	NS
2	04.04.18	AS CONSTRUCTED	GPB	MO	NS

W&G

WALLBRIDGE & GILBERT

Consulting Engineers

60 Wyatt Street Adelaide

South Australia 5000

Telephone (08) 8223 7433

Facsimile (08) 8232 0967

Email adelaide@wgeng.com

W&G Engineers Pty Ltd ACN 052 528 926

trading as Wallbridge & Gilbert

PENNESHAW CWMS No. 271

KANGAROO ISLAND COUNCIL

KANGAROO ISLAND, SOUTH AUSTRALIA

SEWER DRAINAGE PLAN 1/4

A1

Design

MM

DRAWING NUMBER

Job Number

C070466

Sheet No.

C101

Rev.

2

KANGAROO ISLAND COUNCIL
43 Dauncey Street
Kangaroo Island S.A. 5223
Ph. (08) 8553 4534
Facs. (08) 8553 0251

I:\2007\04Apr2007\C070466\Drawings\C070466-C101.dwg, 2, 5/4/2018 11:38 AM, gborodskiy



AS CONSTRUCTED



A1	DRAWING NUMBER		
	Job Number	Sheet No.	Rev.
Design MM	Drawn .JPF	C070466	C102 2

KANGAROO ISLAND COUNCIL
43 Dauncey Street
Kangaroo Island S.A. 5223
Ph. (08) 8553 4534
Facs. (08) 8553 0251

1:2007/04Apr/2007/C070466 Drawings/C070466-C103.dwg, 1, 5/4/2016 11:52 AM, gbnrdsbky

LEGEND:

  - GRAVITY SEWER MAIN
- RISING MAIN
- HYDRANT VALVE, STOP VALVE, AIR VALVE
- SEWER INSPECTION OPENING (IO)
- MAINTENANCE SHAFT (MS, MSJ OR TMS)
- MAINTENANCE HOLE (MH)
- PROPERTY CONNECTION
- PROPERTY CONNECTION SURFACE LEVEL
- PROPERTY CONNECTION INVERT LEVEL
- DEPTH OF CONNECTION
- MONO INVISIQ PUMP CHAMBER
- EXISTING WATERMAIN
- EXISTING TELSTRA CABLE
- EXISTING STORMWATER PIPE



SCALE 1:1000

Information used in this application was derived from digital databases sourced by Kangaroo Island Council.
Therefore, Kangaroo Island Council cannot accept any responsibility for any errors, omissions, or positional accuracy displayed on these maps.

AS CONSTRUCTED

REV.	DATE	DESCRIPTION	DRAFT	ENG.	CHKD
A	04.06.14	COUNCIL APPROVAL	AW	MM	
B	03.10.14	ISSUE FOR DAC	JPF	MM	
C	01.04.15	ISSUE FOR TENDER	JJW	TB	
D	27.04.15	ISSUE FOR TENDER	JJF	TB	
Ø	23.11.2015	CONSTRUCTION ISSUE	JPF	TB	
I	04.04.18	AS CONSTRUCTED	GPB	MO	

W&G
WALLBRIDGE & GILBERT
Consulting Engineers
60 Wyatt Street Adelaide South Australia 5000
Telephone (08) 8223 7433 Facsimile (08) 8232 0967
Email adelaide@wngeng.com
W&G Engineers Pty Ltd ACN 052 528 926
trading as Wallbridge & Gilbert

PENNESHAW CWMS No. 271
KANGAROO ISLAND COUNCIL
KANGAROO ISLAND, SOUTH AUSTRALIA
SEWER DRAINAGE PLAN 3/4

A1	DRAWING NUMBER	Sheet No.	Rev.
Design MM	Job Number C070466	C103	1



PUMP STATION 'PS2' SCHEDULE

PUMP STATION NAME	PS2
PUMP STATION PEAK INFLOW	7.3 l/s
CHAMBER SIZE	3.00mØ
TOP OF TANK	3.60m AHD
INLET PIPE INVERT	2.67m AHD
CHAMBER INVERT	0.25m AHD
EMERGENCY STORAGE CHAMBER SIZE	3.00mØ
INVERT OF EMERGENCY STORAGE CHAMBER	1.34m AHD
HIGH HIGH LEVEL ALARM	1.20m AHD
HIGH LEVEL ALARM	1.05m AHD
STANDBY PUMP ON	0.90m AHD
DUTY PUMP ON	0.75m AHD
PUMP CUT OUT	0.50m AHD
PUMP MODEL (FLYGT PRODUCT)	NP3171.1815H-213mm IMP
OPERATIONAL DUTY	10.5 l/s AT 58.9m



- LEGEND:
- COMPACTED RUBBLE
 - CHAIN MESH FENCE
 - STOCK FENCE
 - GATE POST
 - ELECTRICAL PIT
 - SEWER RISING MAIN

I:\2007\04Apr2007\C070466\Drawings\C070466-C104.dwg, 1:54/2018 11:45 AM, gbrooksby

Information used in this application was derived from digital databases sourced by Kangaroo Island Council. Therefore, Kangaroo Island Council cannot accept any responsibility for any errors, omissions, or positional accuracy displayed on these maps.



AS CONSTRUCTED


REV.	DATE	DESCRIPTION	DRAFT	ENG.	CHKD
C	03.11.14	REVISED ISSUE FOR COUNCIL	JJW	MM	
D	25.02.15	REVISED ISSUE FOR COUNCIL	JJF	MM	NS
E	01.04.15	ISSUE FOR TENDER	JJW	TB	
F	27.04.15	ISSUE FOR TENDER	JJF	TB	
G	05.08.15	DEPARTMENT OF HEALTH APPROVAL	CJH	TB	
Ø	23.11.2015	CONSTRUCTION ISSUE	JPF	TB	
1	04.04.18	AS CONSTRUCTED	GPB	MO	

W&G
WALLBRIDGE & GILBERT
Consulting Engineers
60 Wyatt Street Adelaide South Australia 5000
Telephone (08) 8223 7433 Facsimile (08) 8232 0967
Email adelaide@wgeng.com
W&G Engineers Pty Ltd ACN 052 528 926
trading as Wallbridge & Gilbert

PENNESHAW CWMS No. 271
KANGAROO ISLAND COUNCIL
KANGAROO ISLAND, SOUTH AUSTRALIA
LAGOON & IRRIGATION AREA OVERALL LAYOUT ©

A1		DRAWING NUMBER		
Design	Drawn	Job Number	Sheet No.	Rev.
MM	JPF	C070466	C104	1

KANGAROO ISLAND COUNCIL
43 Dauncey Street
Kangaroo Island S.A. 5223
Ph. (08) 8553 4534
Facs. (08) 8553 0251

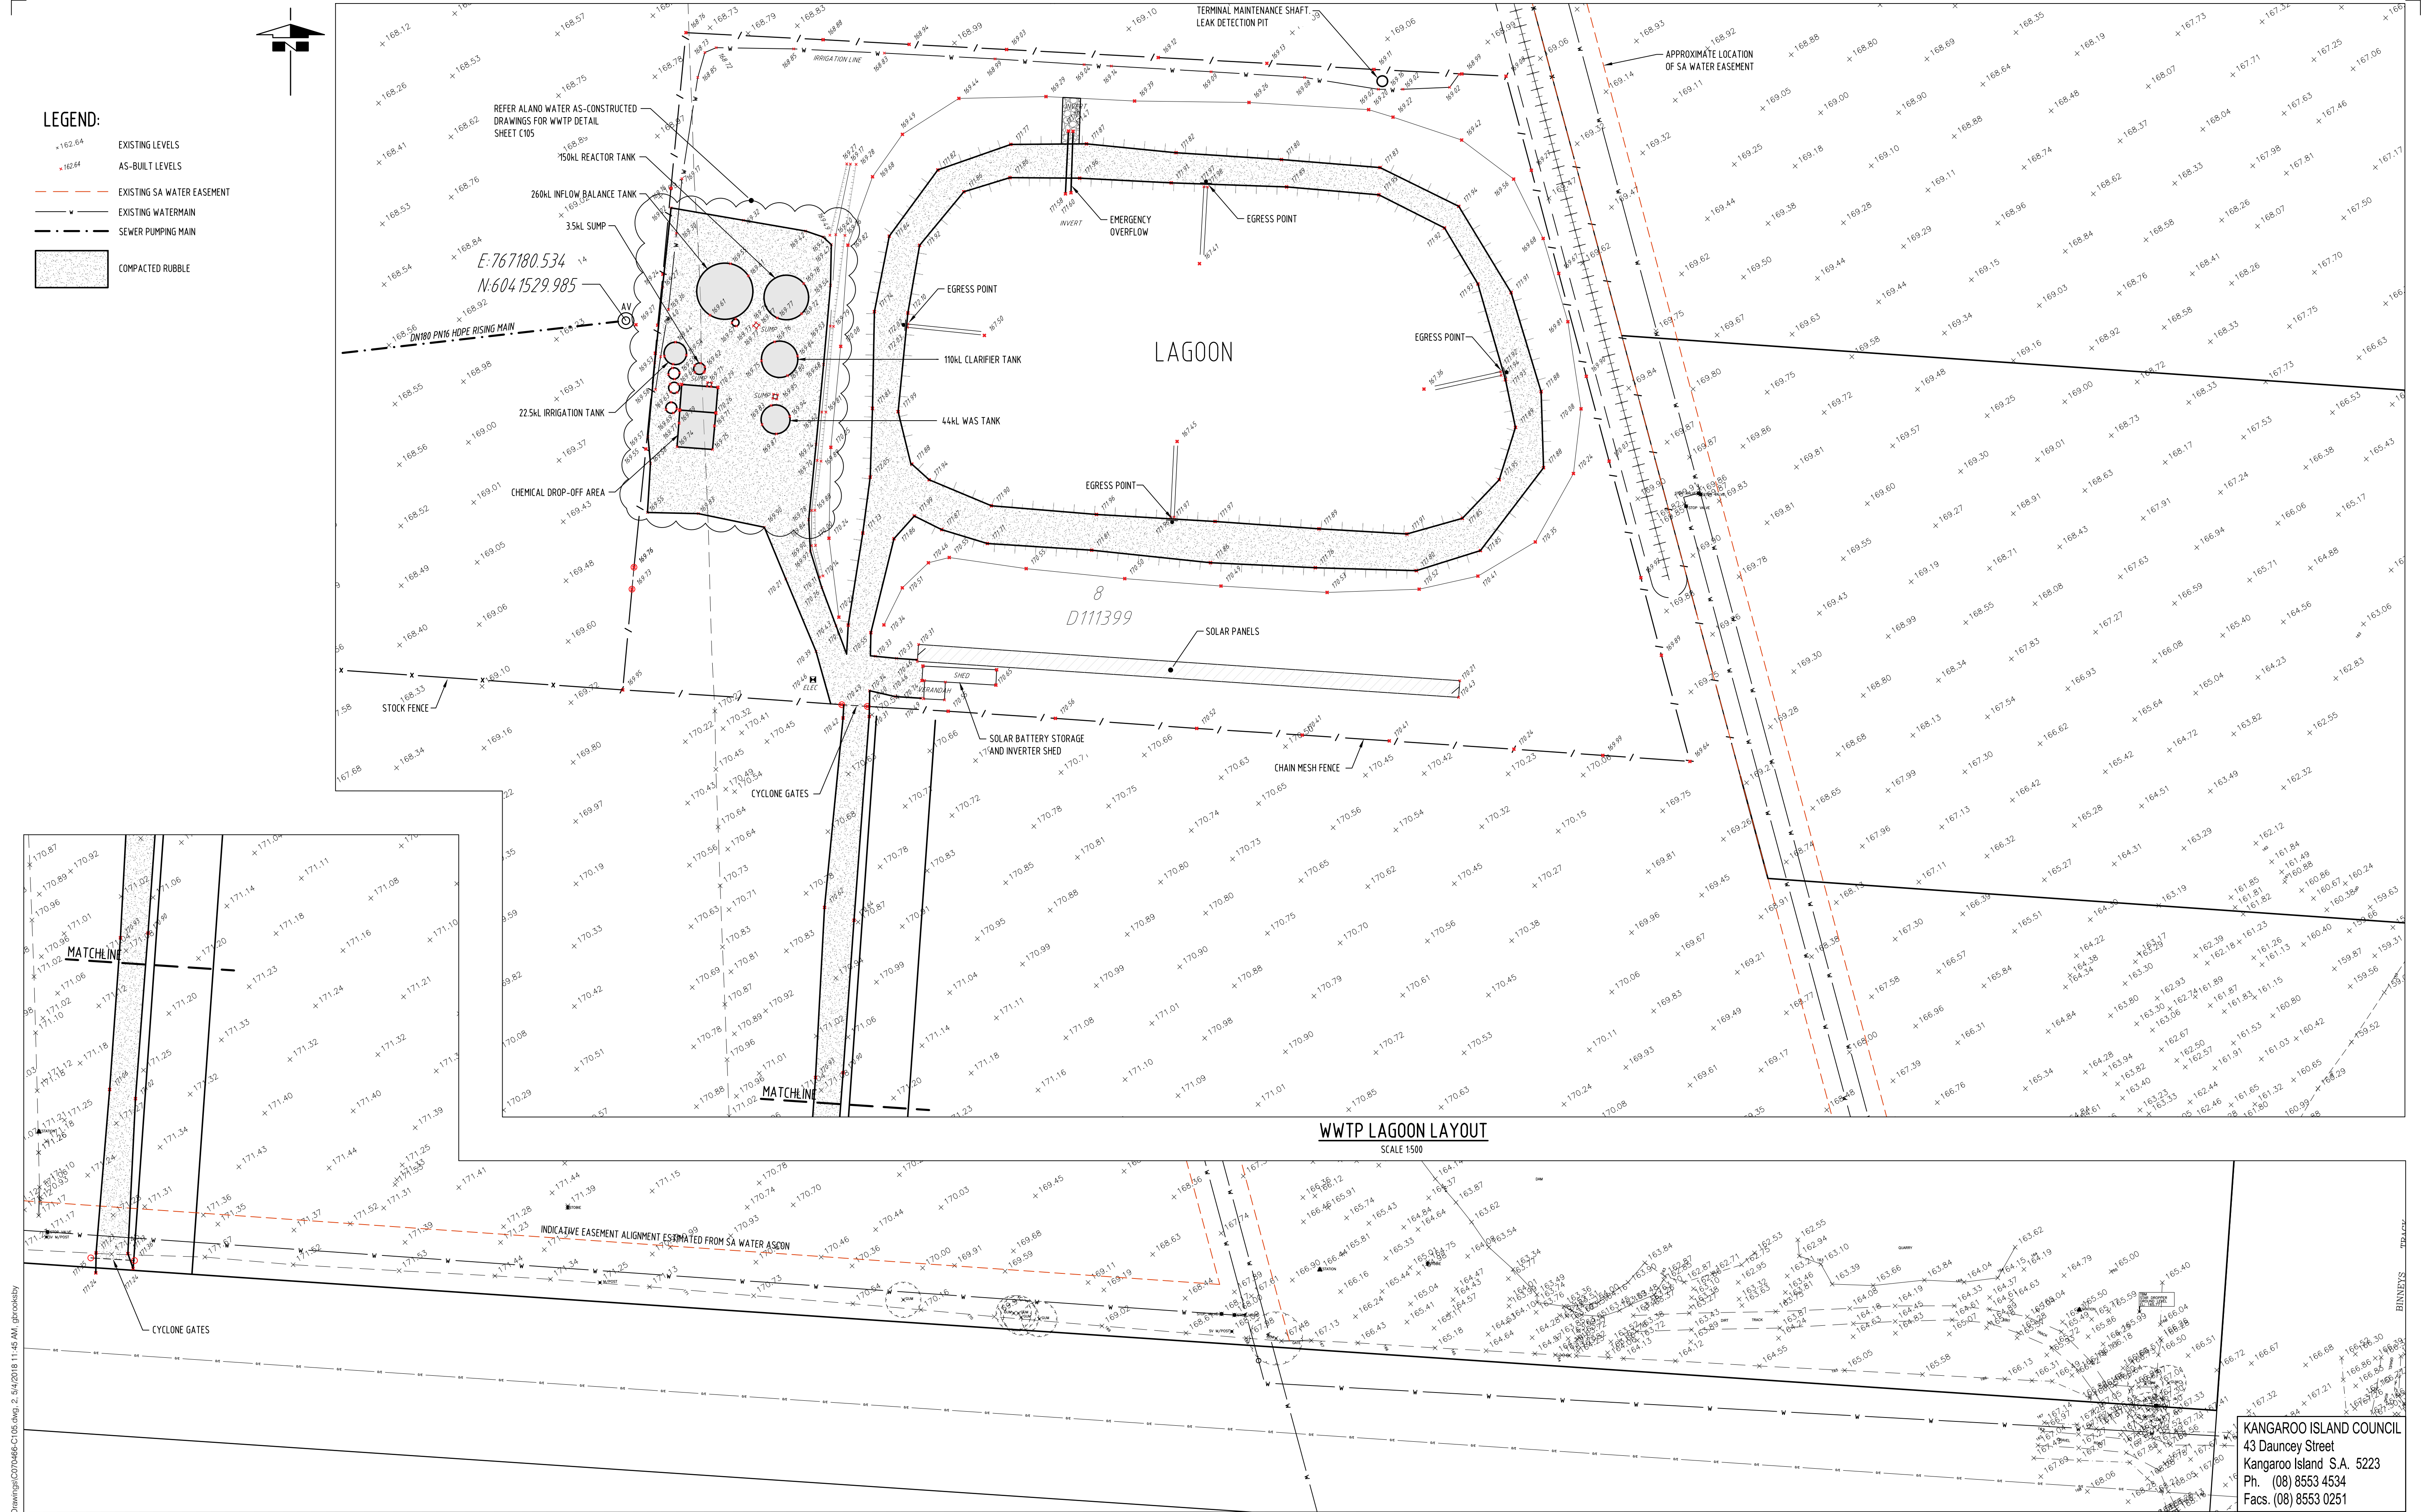

I:\2007\04Apr2007\C070466\Drawings\C070466-C105.dwg, 2, 5/4/2018 11:45 AM, gbrooksby

REV.	DATE	DESCRIPTION	DRAFT	ENG.	CHKD
C	03.11.14	REVISED ISSUE FOR COUNCIL	JJW	MM	
D	25.02.15	REVISED ISSUE FOR COUNCIL	JJF	MM	NS
E	01.04.15	ISSUE FOR TENDER	JJW	TB	
F	27.04.15	ISSUE FOR TENDER	JJF	TB	
G	23.11.2015	CONSTRUCTION ISSUE	JPF	TB	
1	02.12.2015	AMENDMENTS AS CLOUDED	JJF	TB	
2	04.04.18	AS CONSTRUCTED	GPB	MO	

W&G
WALLBRIDGE & GILBERT
Consulting Engineers
60 Wyatt Street Adelaide South Australia 5000
Telephone (08) 8223 7433 Facsimile (08) 8232 0967
Email adelaide@wgeng.com
W&G Engineers Pty Ltd ACN 052 528 926
trading as Wallbridge & Gilbert

PENNESHAU CWMS No. 271
KANGAROO ISLAND COUNCIL
KANGAROO ISLAND, SOUTH AUSTRALIA
LAGOON LAYOUT PLAN

A1
Design
MM

 
DRAWING NUMBER
Job Number
Sheet No.
Rev.

C070466
C105
2




LEGEND:

- GRAVITY SEWER MAIN
- RISING MAIN
- HYDRANT VALVE, STOP VALVE, AIR VALVE
- SEWER INSPECTION OPENING (IO)
- MAINTENANCE SHAFT (MS, MSJ OR TMS)
- MAINTENANCE HOLE (MH)
- PROPERTY CONNECTION
- PROPERTY CONNECTION SURFACE LEVEL
- PROPERTY CONNECTION INVERT LEVEL
- DEPTH OF CONNECTION
- MONO INVISIO PUMP CHAMBER
- EXISTING WATERMAIN
- EXISTING TELSTRA CABLE
- EXISTING STORMWATER PIPE



 Information used in this application was derived from digital databases sourced by Kangaroo Island Council.
Therefore, Kangaroo Island Council cannot accept any responsibility for any errors, omissions, or positional accuracy displayed on these maps.



AS CONSTRUCTED


REV.	DATE	DESCRIPTION	DRAFT	ENG.	CHKD
B	03.10.14	ISSUE FOR DAC	JPF	MM	
C	01.04.15	ISSUE FOR TENDER	JJW	TB	
D	27.04.15	ISSUE FOR TENDER	JJF	TB	
E	23.11.2015	CONSTRUCTION ISSUE	JPF	TB	
1	26.07.16	LINES 411, 412, 413, 415, 420 & 421 AMENDED	CJH	NS	
2	28.11.16	LINES 410, 411 & 420 AMENDED	CJH	MO	
3	04.04.18	AS CONSTRUCTED	GPB	MO	

W&G
WALLBRIDGE & GILBERT
Consulting Engineers
80 Wyatt Street Adelaide South Australia 5000
Telephone (08) 8223 7433 Facsimile (08) 8232 0967
Email adelaide@wgeng.com
W&G Engineers Pty Ltd ACN 052 528 926
trading as Wallbridge & Gilbert

PENNESHAU CWMS No. 271
KANGAROO ISLAND COUNCIL
KANGAROO ISLAND, SOUTH AUSTRALIA
SEWER DRAINAGE PLAN 4/4

A1	DRAWING NUMBER	Rev.
Design MM	Job Number C070466	Sheet No. C115
Drawn JPF		3

 KANGAROO ISLAND COUNCIL
43 Dauncey Street
Kangaroo Island S.A. 5223
Ph. (08) 8553 4534
Facs. (08) 8553 0251



REFER BELOW

SCALE 1:1000

PUMP STATION NAME	PS3
PUMP STATION PEAK INFLOW	10.5 l/s
CHAMBER SIZE	3.00m ³
TOP OF TANK	56.29m AHD
INLET PIPE INVERT	----- m AHD
CHAMBER INVERT	54.28m AHD
HIGH HIGH LEVEL ALARM	55.95m AHD
HIGH LEVEL ALARM	55.80m AHD
STANDBY PUMP ON	55.65m AHD
DUTY PUMP ON	55.50m AHD
PUMP CUT OUT	55.15m AHD
PUMP MODEL (FLYGT PRODUCT)	NP371T.1815H-213 IMP
OPERATIONAL DUTY	10.5 l/s AT 58.9m

PUMP STATION NAME	PS3
PUMP STATION PEAK INFLOW	10.5 l/s
CHAMBER SIZE	3.00m ³
TOP OF TANK	56.29m AHD
INLET PIPE INVERT	----- m AHD
CHAMBER INVERT	54.28m AHD
HIGH HIGH LEVEL ALARM	55.95m AHD
HIGH LEVEL ALARM	55.80m AHD
STANDBY PUMP ON	55.65m AHD
DUTY PUMP ON	55.50m AHD
PUMP CUT OUT	55.15m AHD
PUMP MODEL (FLYGT PRODUCT)	NP371T.1815H-213 IMP
OPERATIONAL DUTY	10.5 l/s AT 58.9m

PUMP STATION NAME	PS4
PUMP STATION PEAK INFLOW	10.5 1/s
CHAMBER SIZE	3.00mØ
TOP OF TANK	113.26m AHD
INLET PIPE INVERT	112.42m AHD
CHAMBER INVERT	111.28m AHD
HIGH HIGH LEVEL ALARM	112.60m AHD
HIGH LEVEL ALARM	112.45m AHD
STANDBY PUMP ON	112.30m AHD
DUTY PUMP ON	112.15m AHD
PUMP CUT OUT	111.80m AHD
PUMP MODEL (FLYGT PRODUCT)	NP3711.1815H-Z26 IMP
OPERATIONAL DUTY	10.0 1/s AT 66.0m

PUMP STATION NAME	PS4
PUMP STATION PEAK INFLOW	10.5 1/s
CHAMBER SIZE	3.00mØ
TOP OF TANK	113.26m AHD
INLET PIPE INVERT	112.42m AHD
CHAMBER INVERT	111.28m AHD
HIGH HIGH LEVEL ALARM	112.60m AHD
HIGH LEVEL ALARM	112.45m AHD
STANDBY PUMP ON	112.30m AHD
DUTY PUMP ON	112.15m AHD
PUMP CUT OUT	111.80m AHD
PUMP MODEL (FLYGT PRODUCT)	NP3711.1815H-Z26 IMP
OPERATIONAL DUTY	10.0 1/s AT 66.0m



REFER TO SHEET C123

SCALE 1:1000

 GRAVITY SEWER MAIN
 RISING MAIN
 HYDRANT VALVE, STOP VALVE, AIR VALVE
 SEWER INSPECTION OPENING (IO)
 MAINTENANCE SHAFT (MS, MSJ or TMS)
 MAINTENANCE HOLE (MH)
 PROPERTY CONNECTION
 PROPERTY CONNECTION SURFACE LEVEL
 PROPERTY CONNECTION INVERT LEVEL
 DEPTH OF CONNECTION
 MONO INVISIQ PUMP CHAMBER
 EXISTING WATERMAIN
 EXISTING TELSTRA CABLE
 EXISTING STORMWATER PIPE



Information used in this application was derived from digital databases sourced by Kangaroo Island Council.

Therefore, Kangaroo Island Council cannot accept any responsibility for any errors, omissions, or positional accuracy displayed on these maps.

AS CONSTRUCTED

REV.	DATE	DESCRIPTION	DRAFT	ENG.	CHKD.
A	04.06.14	COUNCIL APPROVAL	JJW	MM	
B	03.10.14	ISSUE FOR DAC	JPF	MM	
C	01.04.15	ISSUE FOR TENDER	JJW	TB	
D	27.04.15	ISSUE FOR TENDER	JJW	TB	
Ø	23.11.2015	CONSTRUCTION ISSUE	JPF	TB	
I	04.04.18	AS CONSTRUCTED	GPB	MO	

W&G
WALLBRIDGE & GILBERT
Consulting Engineers

60 Wyatt Street Adelaide South Australia 5000
Telephone (08) 8223 7433 Facsimile (08) 8232 0900
Email adelaide@wgeng.com


W&G Engineers Pty Ltd ACN 052 528 926
trading as Wallbridge & Gilbert



PENNESHAW CWMS No. 271
KANGAROO ISLAND COUNCIL
KANGAROO ISLAND, SOUTH AUSTRALIA
RISING MAIN PLAN 2/3

A1		DRAWING NUMBER	
Design	Drawn	Job Number	Sheet No.
MM	JJW	C070466	C122

KANGAROO ISLAND COUNCIL
43 Dauncey Street
Kangaroo Island S.A. 5223
Ph. (08) 8553 4534
Facs. (08) 8553 0251

 When sheet printed full size, the scale bar is 100mm.



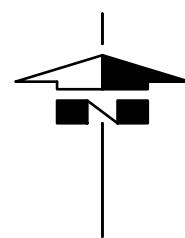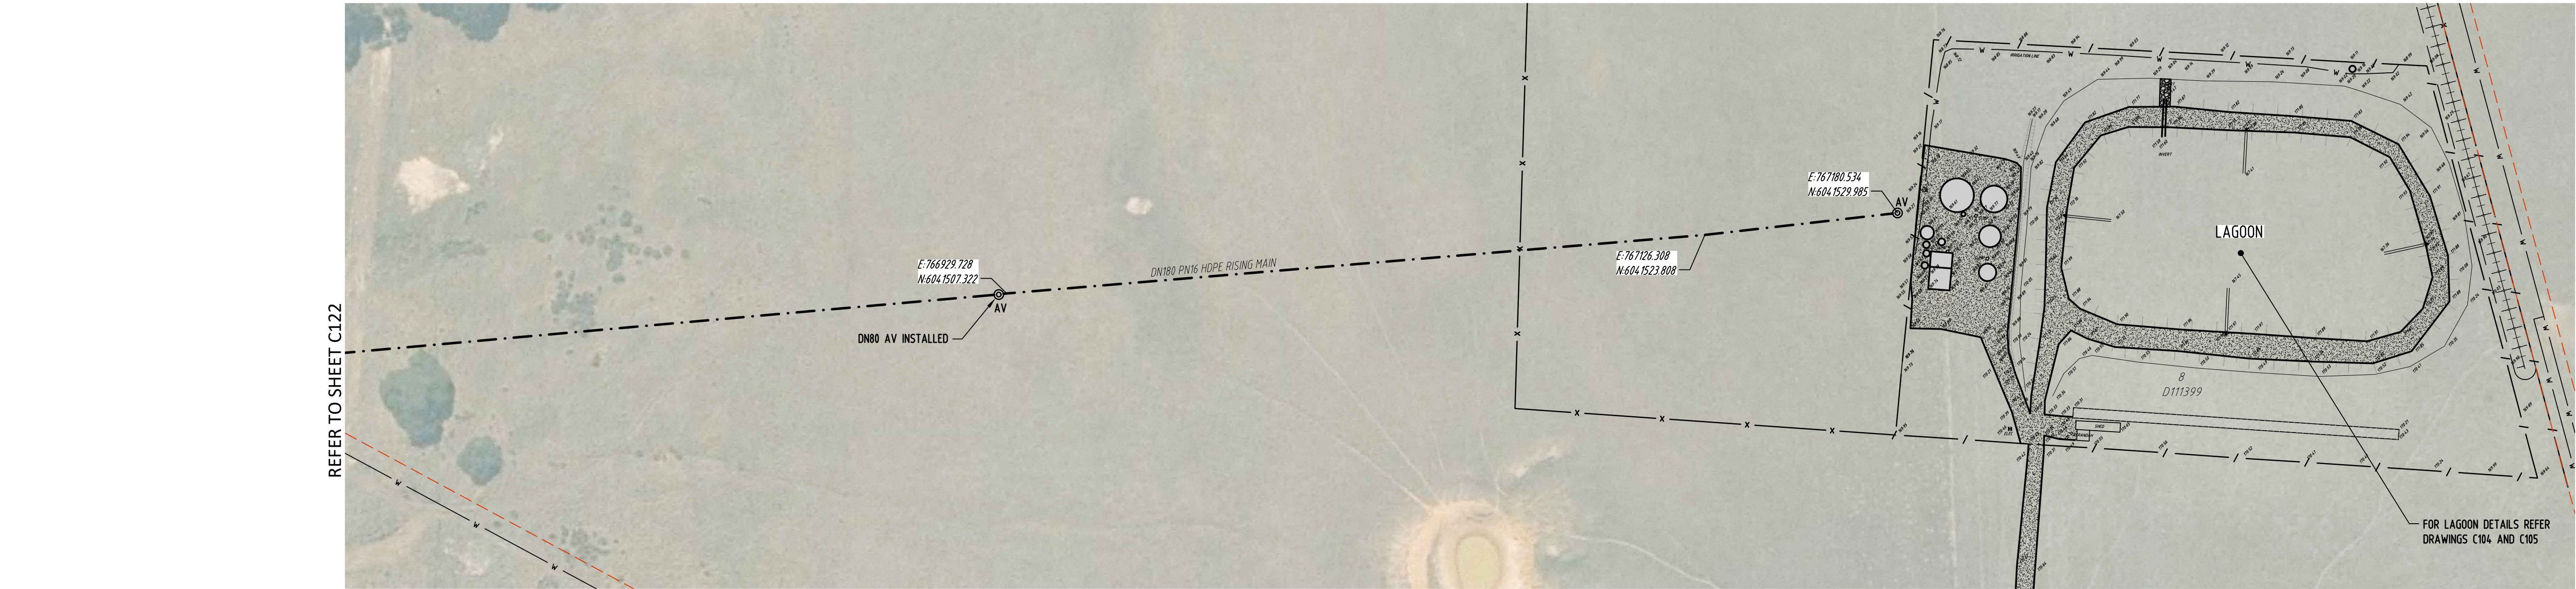


PLAN
SCALE 1:1000

I:\2007\04Apr\2007\C070466\Drawings\C070466-C123.dwg, 1:54/2018 11:55 AM, gborodsky

LEGEND:

 - GRAVITY SEWER MAIN
- RISING MAIN
- HYDRANT VALVE, STOP VALVE, AIR VALVE
- SEWER INSPECTION OPENING (IO)
- MAINTENANCE SHAFT (MS, MSJ OR TMS)
- MAINTENANCE HOLE (MH)
- PROPERTY CONNECTION
- PROPERTY CONNECTION SURFACE LEVEL
- PROPERTY CONNECTION INVERT LEVEL
- DEPTH OF CONNECTION
- MONO INVISIQ PUMP CHAMBER
- EXISTING WATERMAIN
- EXISTING TELSTRA CABLE
- EXISTING STORMWATER PIPE



SCALE 1:1000

Information used in this application was derived from digital databases sourced by Kangaroo Island Council.
Therefore, Kangaroo Island Council cannot accept any responsibility for any errors, omissions, or positional accuracy displayed on these maps.

AS CONSTRUCTED

REV.	DATE	DESCRIPTION	DRAFT	ENG.	CHKD
A	04.06.14	COUNCIL APPROVAL	JJW	MM	
B	03.10.14	ISSUE FOR DAC	JPF	MM	
C	01.04.15	ISSUE FOR TENDER	JJW	TB	
D	27.04.15	ISSUE FOR TENDER	JJW	TB	
Ø	23.11.2015	CONSTRUCTION ISSUE	JPF	TB	
I	04.04.18	AS CONSTRUCTED	GPB	MO	

W&G
WALLBRIDGE & GILBERT
Consulting Engineers
60 Wyatt Street Adelaide South Australia 5000
Telephone (08) 8223 7433 Facsimile (08) 8232 0967
Email adelaide@wgeng.com
W&G Engineers Pty Ltd ACN 052 528 926
trading as Wallbridge & Gilbert

PENNESHAW CWMS No. 271
KANGAROO ISLAND COUNCIL
KANGAROO ISLAND, SOUTH AUSTRALIA
RISING MAIN PLAN 3/3

A1	DRAWING NUMBER
Design MM	Job Number C070466
Drawn JJW	Sheet No. C123
	Rev. 1

KANGAROO ISLAND COUNCIL
43 Dauncey Street
Kangaroo Island S.A. 5223
Ph. (08) 8553 4534
Facs. (08) 8553 0251